
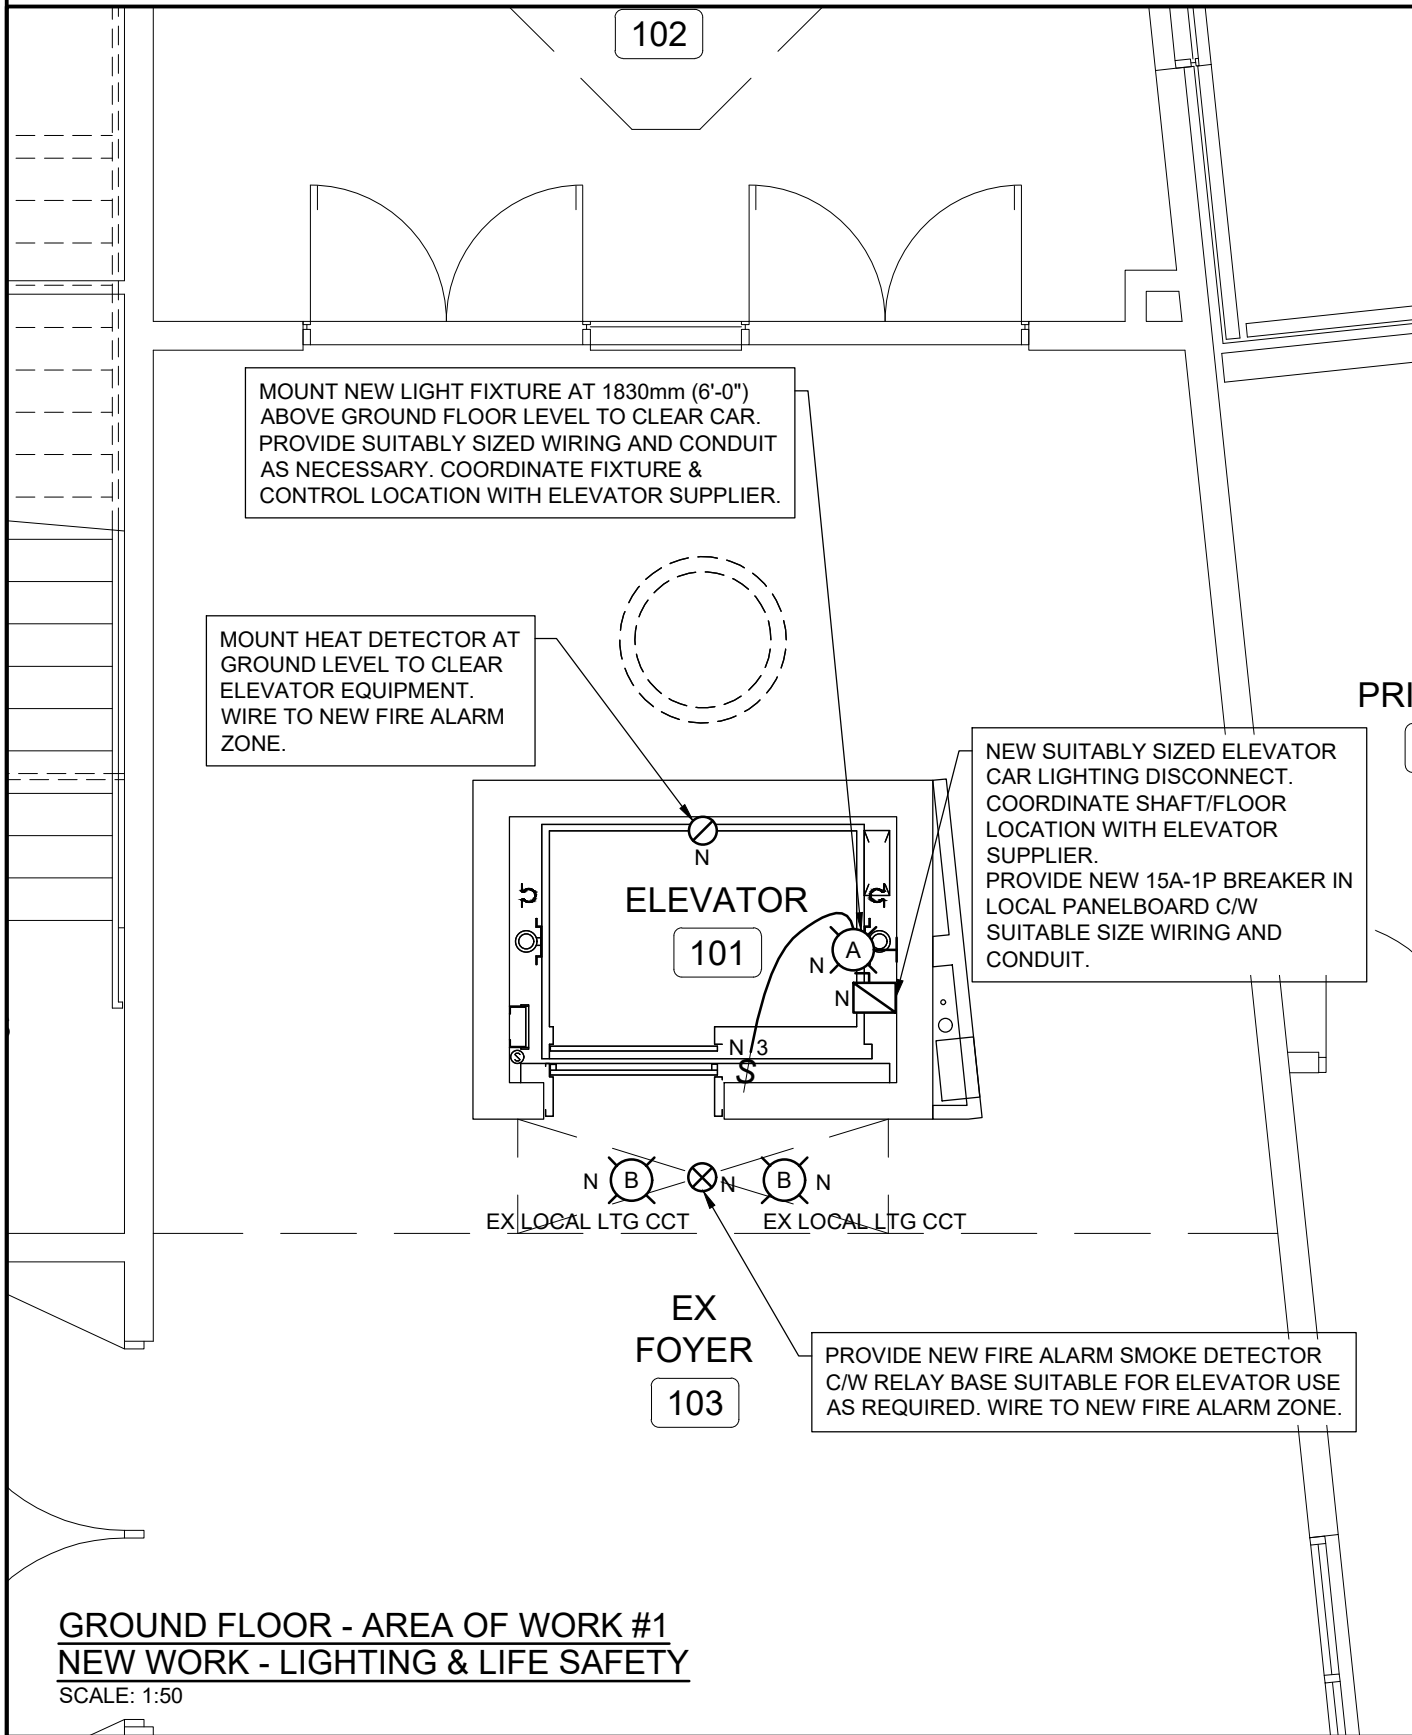


FILENAME: C:\Users\Design\My Documents\Projects\2026\26-006\26-006_S4 - 26-0060 - Bishop Tonnos Elevator E0.01-E3.03 Rev3.dwg
PLOT TIME: Aug 25, 2026 12:05pm
ARCH: D 24X36



DEMOLITION NOTES:

- EXISTING LIGHT FIXTURES TO BE REMOVED AND RETAINED FOR POSSIBLE RE-USE. REDUNDANT FIXTURES TO BE RETAINED FOR OWNER REVIEW AND POSSIBLE RETENTION. DISPOSE OF REDUNDANT FIXTURES OFF-SITE AS DIRECTED. CAP AND MAKE WIRING SAFE. RETAIN EXISTING LIGHTING CIRCUITS FOR POSSIBLE RE-USE.
- REMOVE EXISTING RECEPTACLES AND SWITCHES AS SHOWN. CAP AND MAKE WIRING SAFE. DISCONNECT AT ASSOCIATED BREAKER AND LABEL "SPARE". RETAIN EXISTING RECEPTACLE CIRCUITS FOR RE-USE.
- EXISTING P/A SPEAKERS TO BE REMOVED BY OWNER'S APPROVED P/A SUBCONTRACTOR. RETAIN FOR OWNER REVIEW AND POSSIBLE RETENTION. DISPOSE OF REDUNDANT UNITS OFF-SITE AS DIRECTED. DISCONNECT, CAP AND MAKE ASSOCIATED WIRING SAFE. RETAIN CIRCUITS FOR RE-USE.
- EXISTING FIRE ALARM EQUIPMENT AND ASSOCIATED WIRING TO BE REMOVED AND RETAINED FOR RE-INSTALLATION OR OWNER REVIEW AND POSSIBLE RETENTION. DISPOSE OF REDUNDANT DEVICES OFF-SITE AS DIRECTED. RETAIN EXISTING CIRCUITS FOR RE-USE.
- EXISTING EMERGENCY / EXIT LIGHTING UNITS TO BE REMOVED. RETAINED FOR RE-INSTALLATION OR FOR OWNER REVIEW AND POSSIBLE RETENTION. DISPOSE OF REDUNDANT UNITS OFF-SITE AS DIRECTED. DISCONNECT, CAP AND MAKE ASSOCIATED WIRING SAFE. RETAIN CIRCUITS FOR RE-USE.
- DISCONNECT POWER FEEDS TO EXISTING MECHANICAL EQUIPMENT TO BE REMOVED/RELOCATED BY MECHANICAL CONTRACTOR. RETAIN CIRCUITS FOR RE-USE.
- PROVIDE STAINLESS STEEL COVER PLATES AS REQUIRED FOR ALL REDUNDANT OUTLET BOXES TO REMAIN IN EXISTING WALLS.

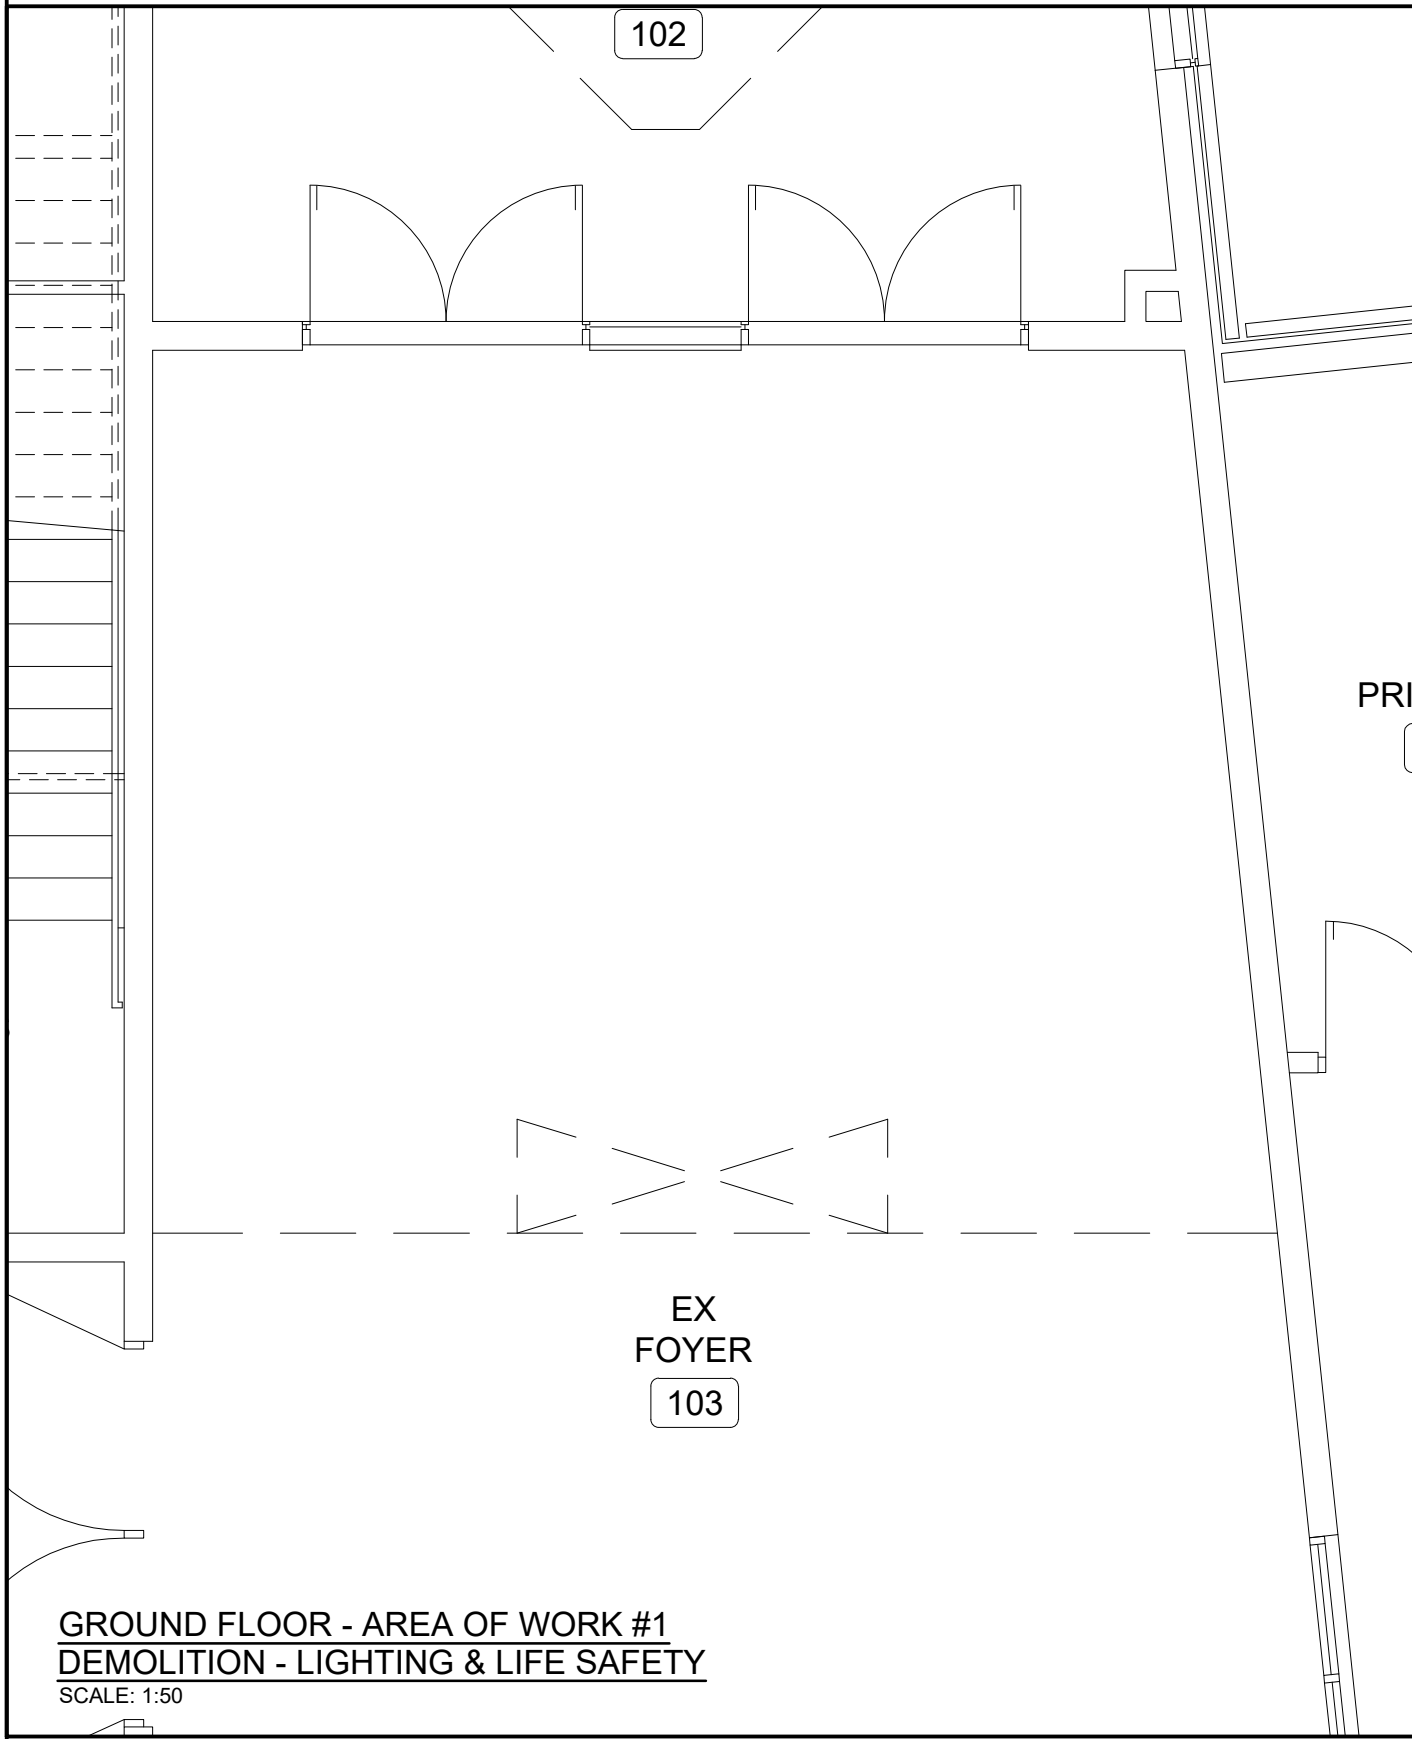



NEW LIGHTING & LIFE SAFETY NOTES:

- PROVIDE NEW INTERIOR LIGHT FIXTURES AS SHOWN. WIRE TO NEW OR EXISTING LOCAL LIGHTING CIRCUITS AS NECESSARY. PROVIDE NEW STANDARD, DIMMING &/OR OCCUPANCY SENSOR LIGHT SWITCHES AS INDICATED.
- PROVIDE NEW EMERGENCY / EXIT "RUNNING MAN" LIGHTING UNITS AS REQUIRED. WIRE TO NEW AC/DC EMERGENCY LIGHTING CIRCUITS AS INDICATED.
- PROVIDE NEW FIRE ALARM SYSTEM DEVICES AS SHOWN. WIRE TO NEW OR EXISTING FIRE ALARM ZONES ON EXISTING FIRE ALARM SYSTEM AS INDICATED.

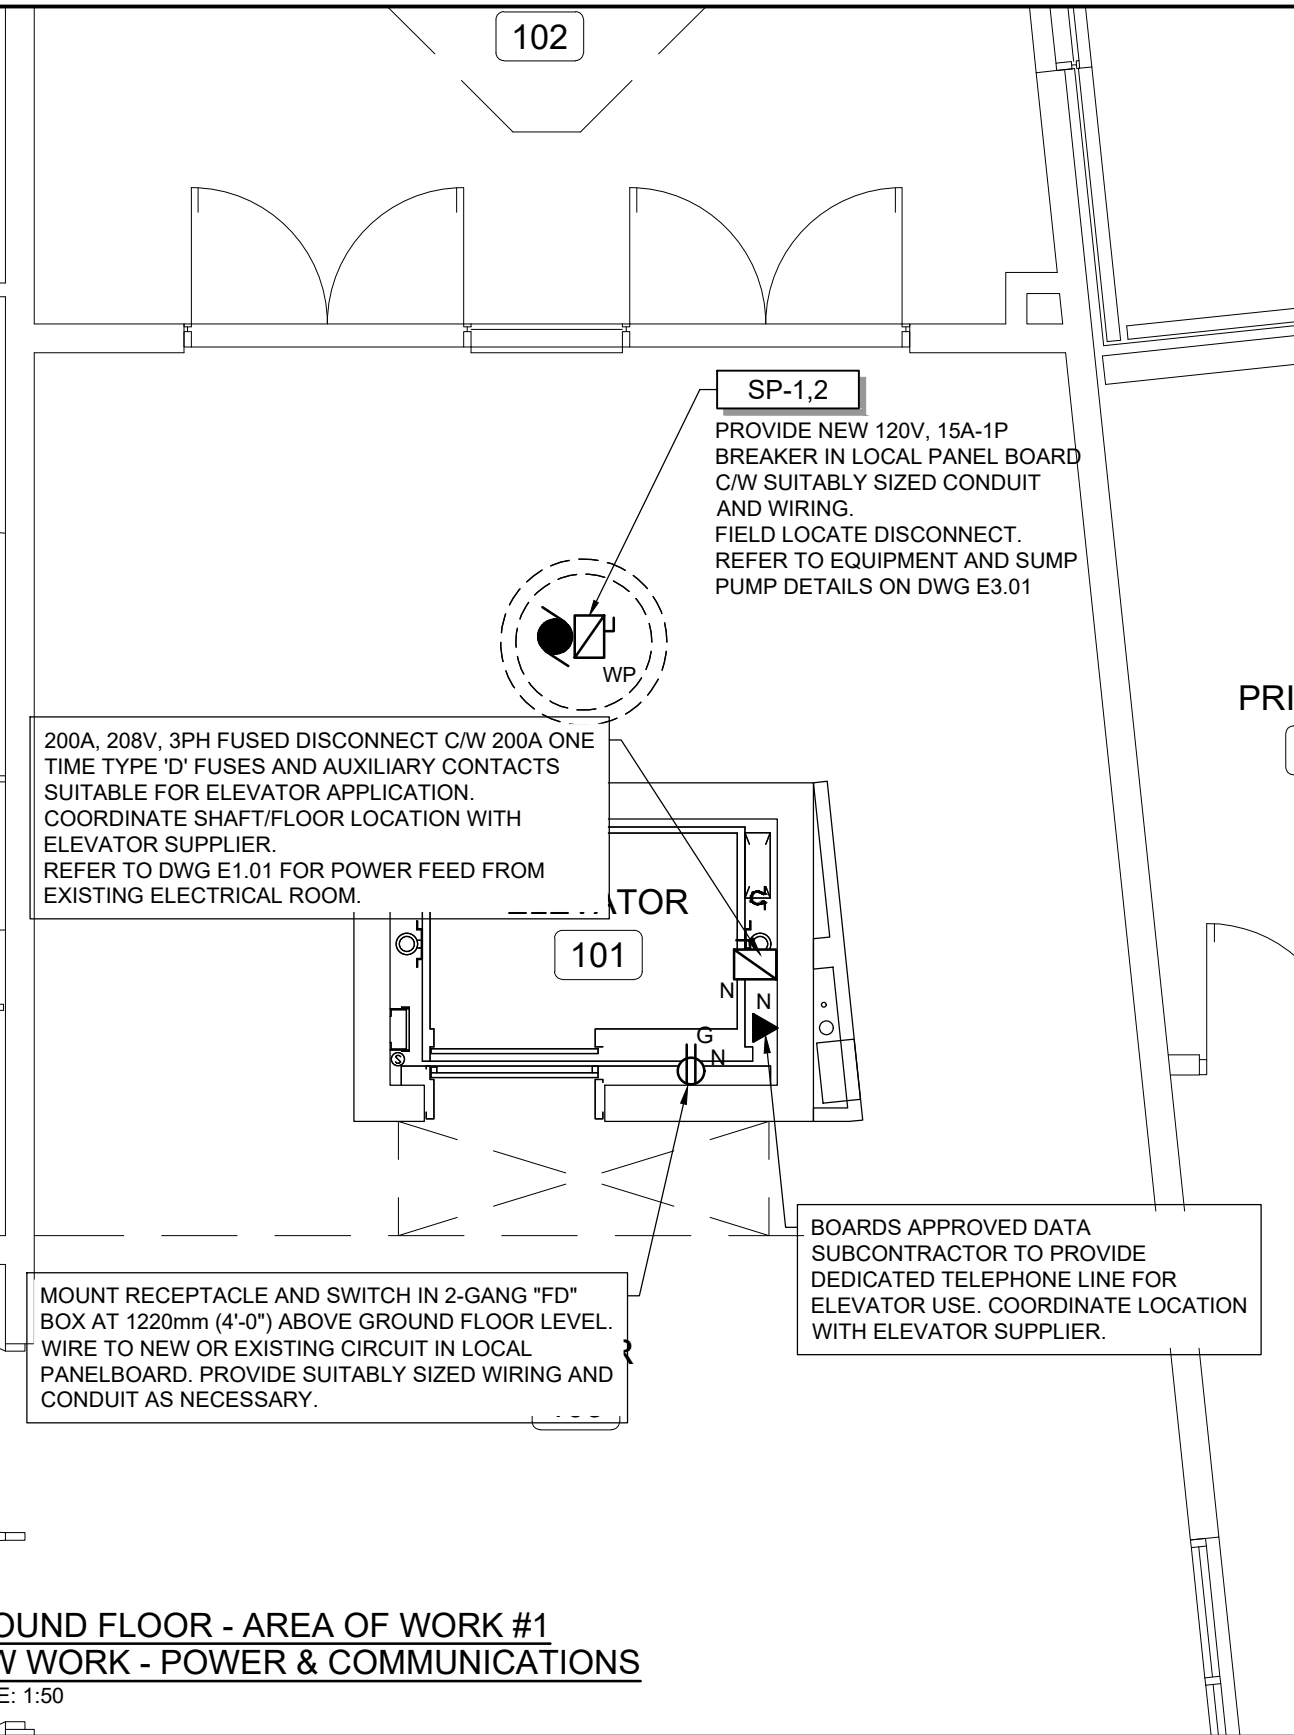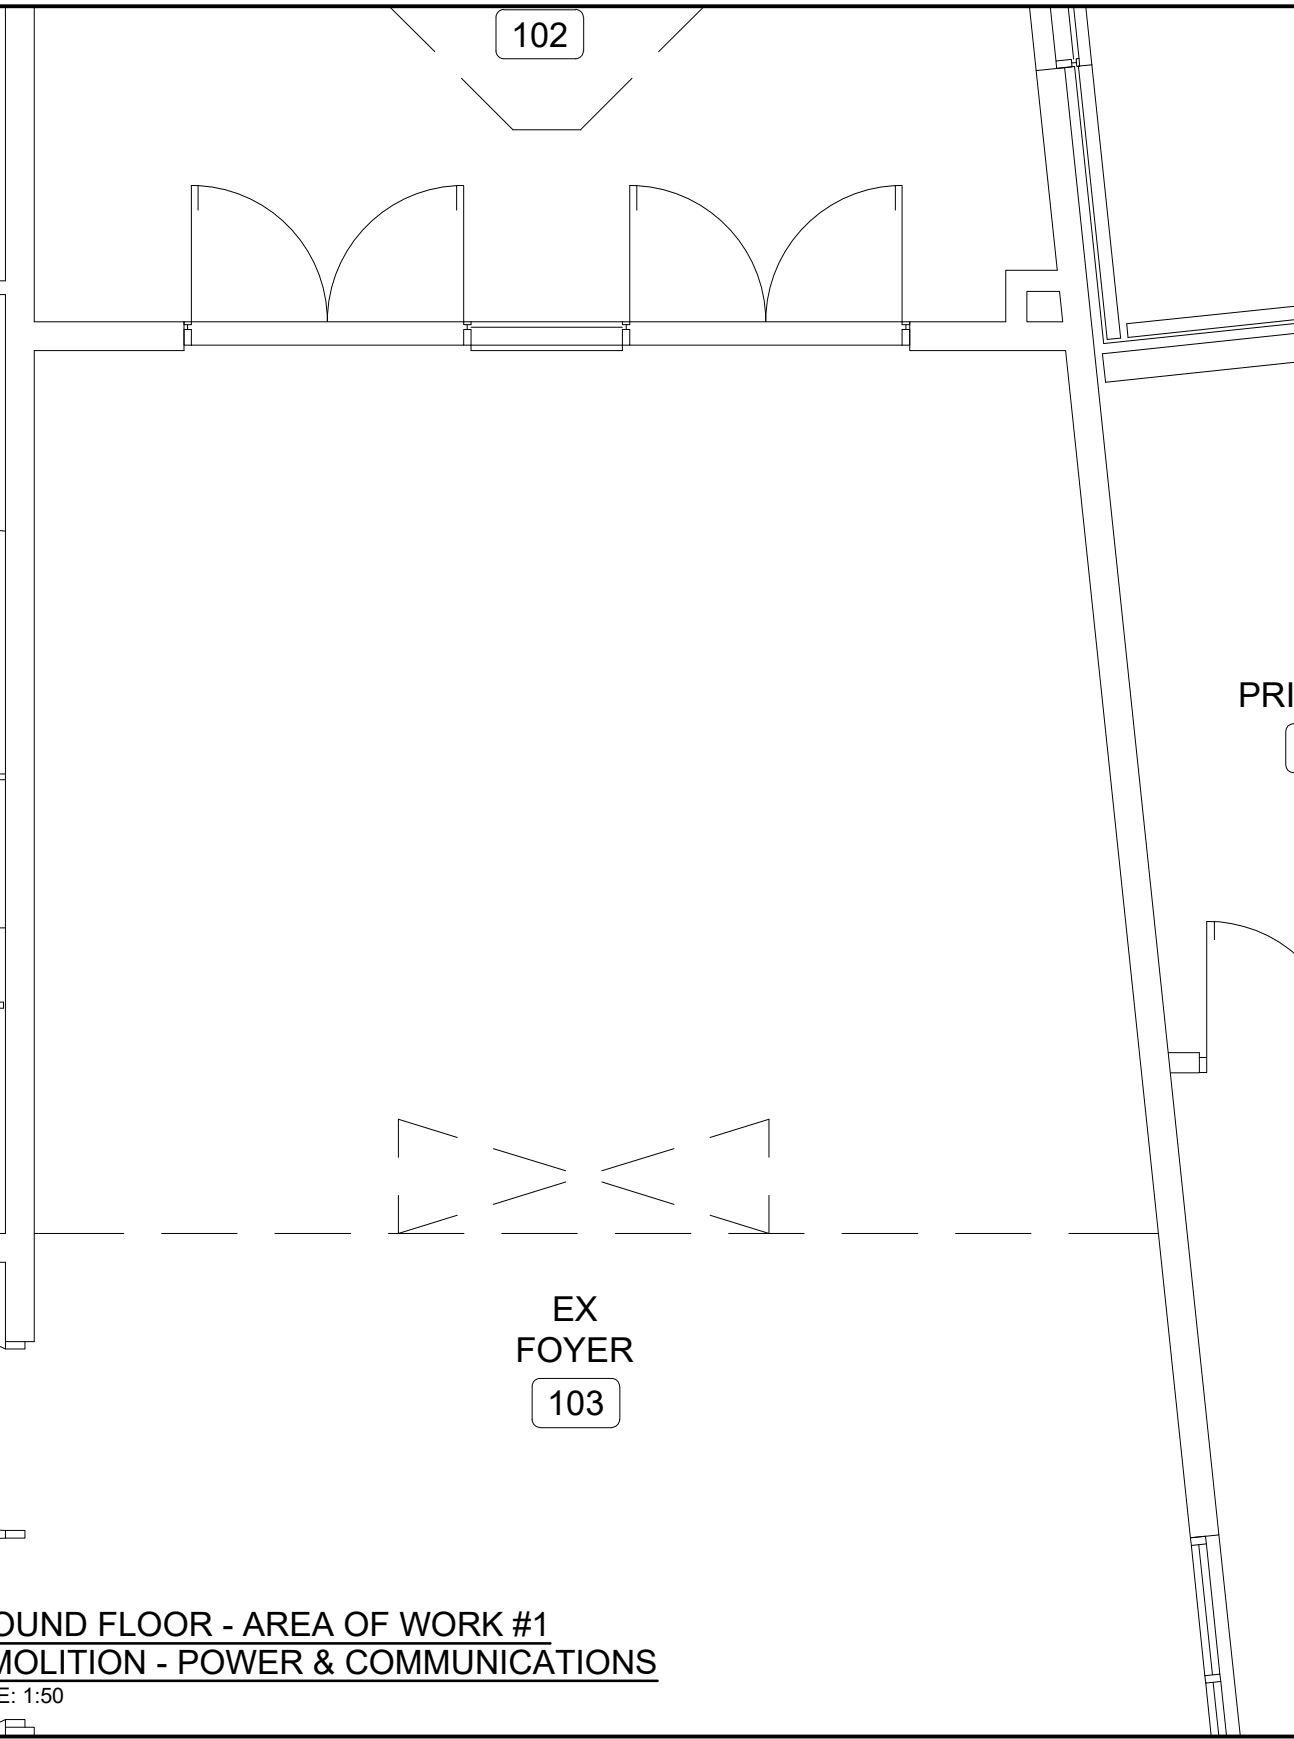

NEW POWER & COMMUNICATIONS NOTES:


- SUPPLY AND INSTALL NEW RECEPTACLES AS SHOWN. WIRE TO NEW OR EXISTING BREAKERS IN NEW LOCAL PANEL BOARDS AS INDICATED. MAXIMUM FOUR (4) RECEPTACLES PER 15A CIRCUIT.
- PROVIDE RECESSED OUTLET BOXES FOR NEW DATA / TELEPHONE OUTLETS AS SHOWN. RETAIN OWNER'S APPROVED DATA / TELEPHONE SUBCONTRACTOR TO SUPPLY, INSTALL, TERMINATE AND TEST DATA & TELEPHONE JACKS C/W CAT6 WIRING FOR DATA AND CAT3 WIRING FOR TELEPHONE.
- PROVIDE NEW POWER FEEDS TO NEW MECHANICAL EQUIPMENT AS REQUIRED. WIRE TO NEW SUITABLY SIZED BREAKERS IN NEW LOCAL PANEL BOARDS AS SHOWN.
- PROVIDE NEW POWER FEEDS TO NEW EQUIPMENT AS INDICATED. EQUIPMENT SUPPLIED BY OTHERS.
- COORDINATE ELEVATOR DISCONNECTS LOCATION IN SHAFT, ELEVATOR POWER REQUIREMENTS/FEED LOCATION WITH ELEVATOR SUPPLIER BEFORE COMMENCING WORK.

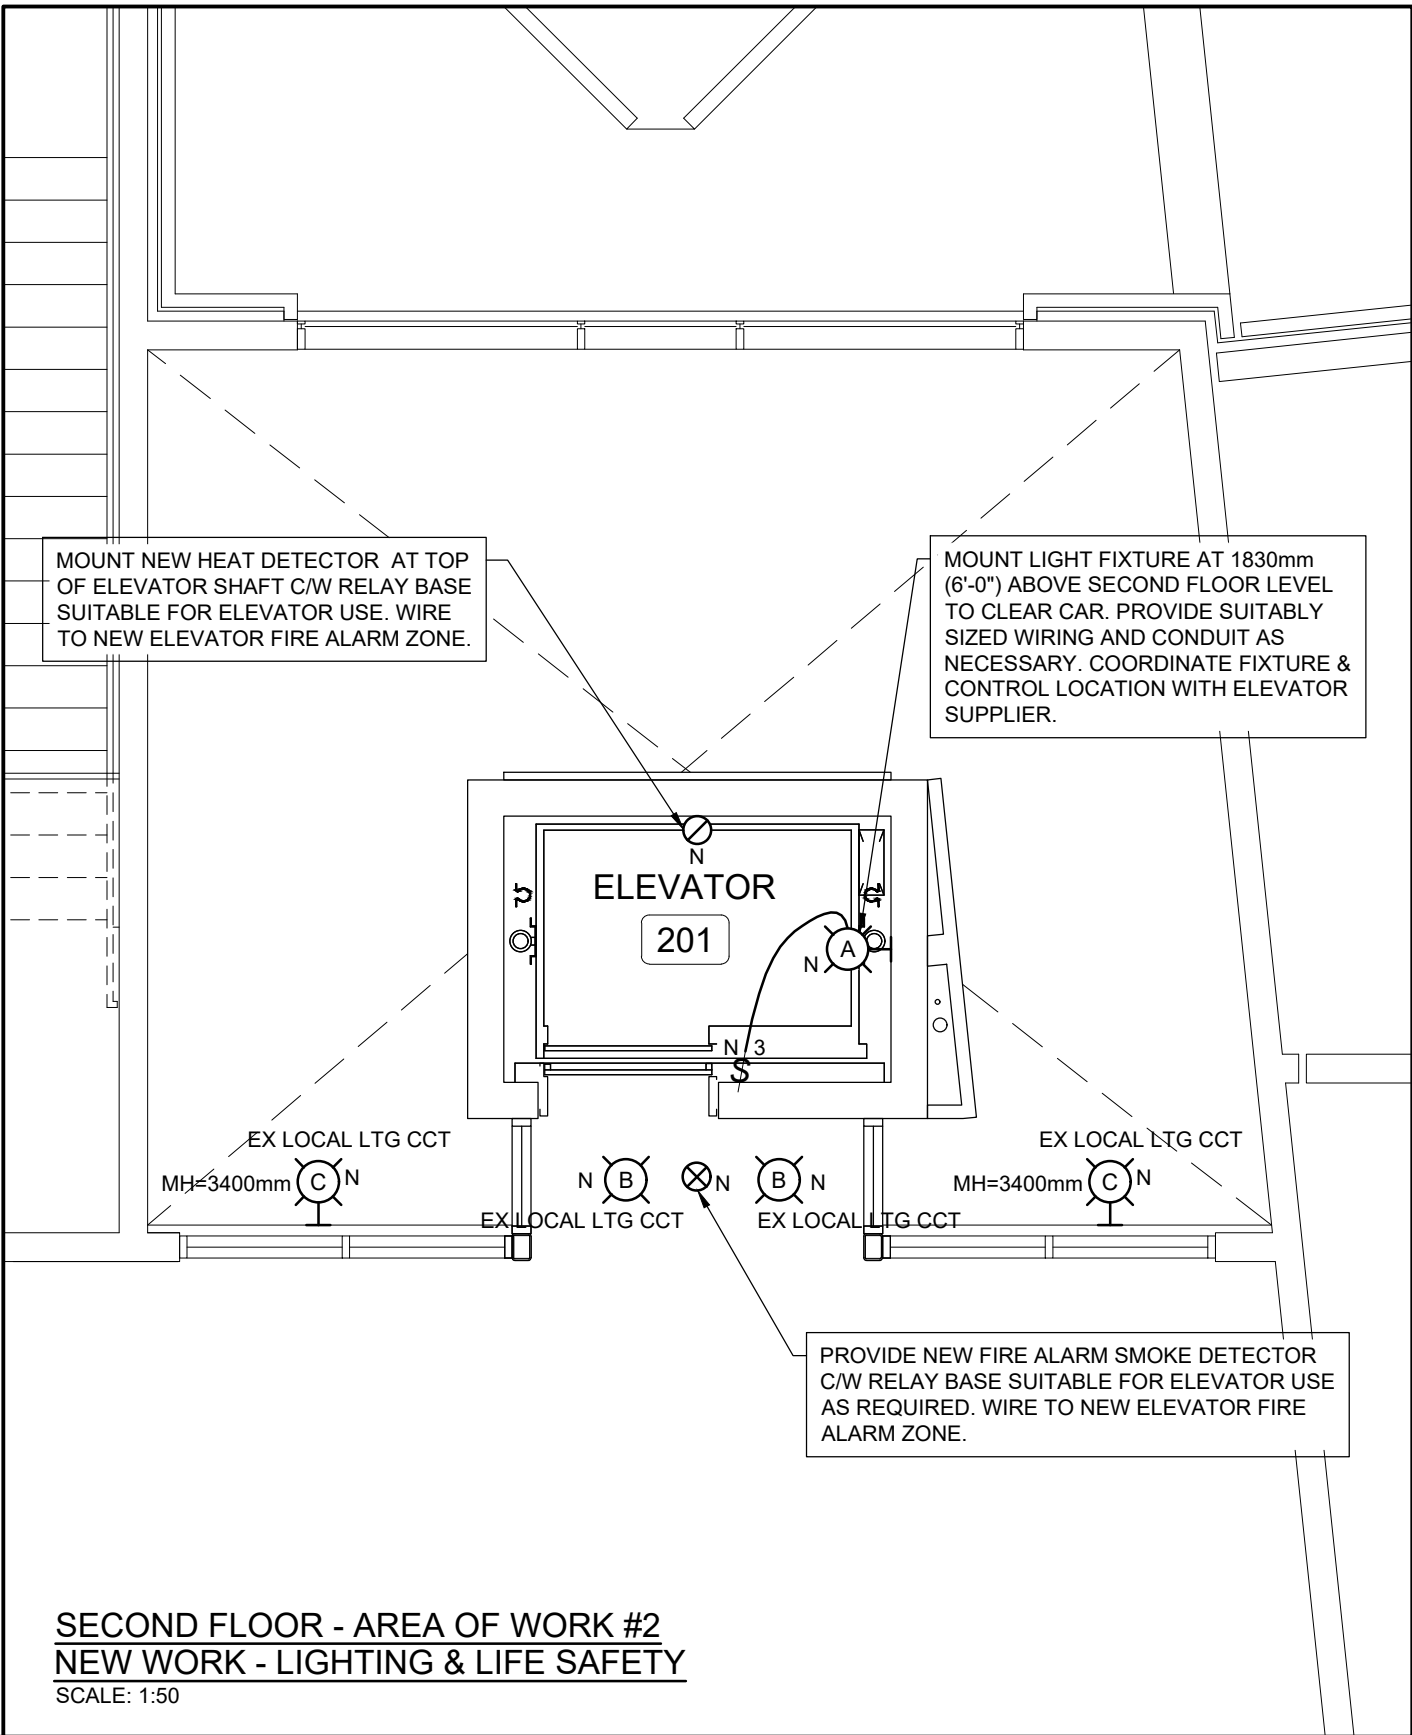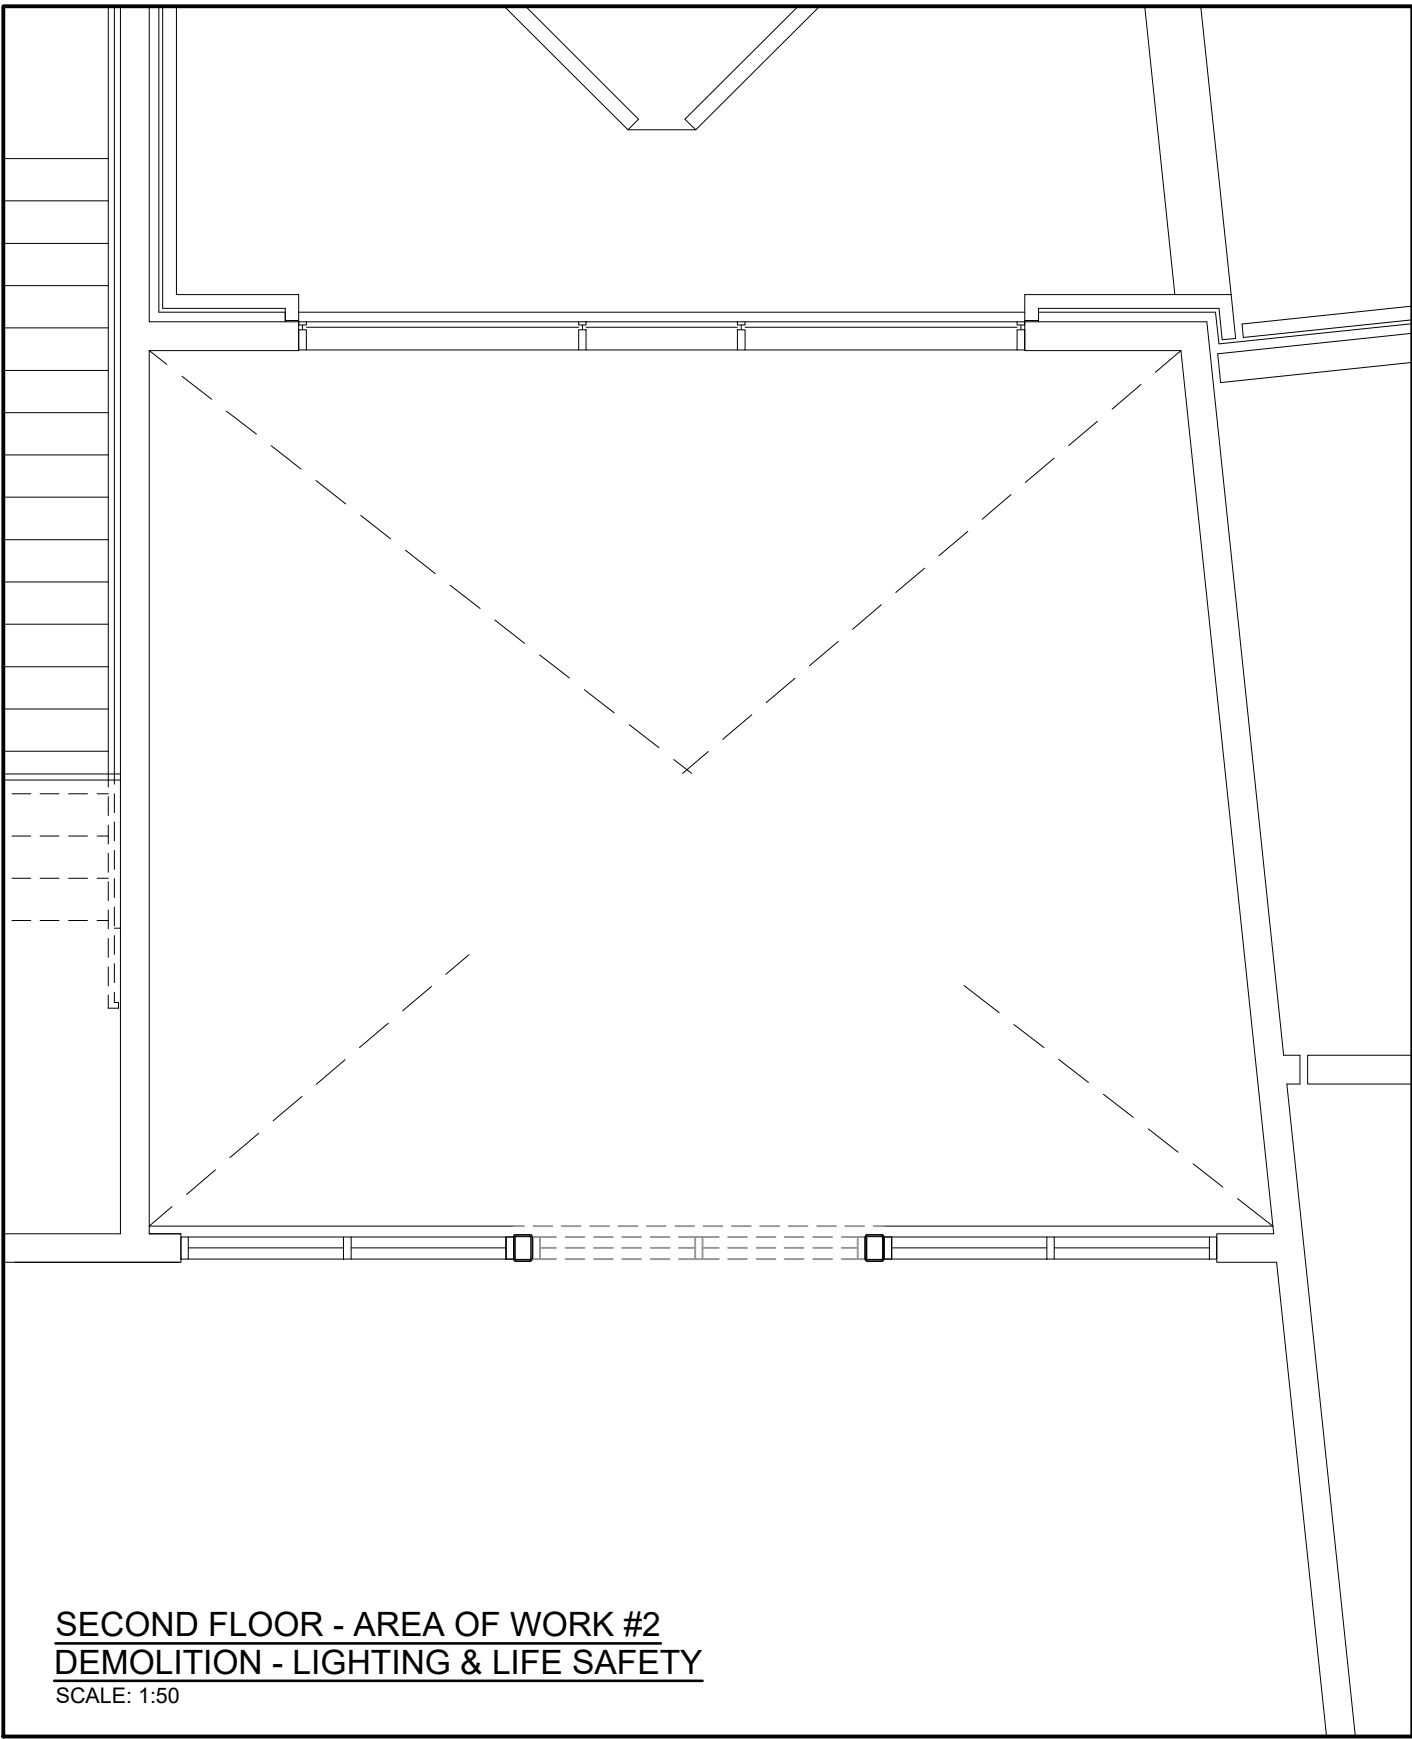


BISHOP TONNES CATHOLIC SECONDARY SCHOOL - NEW ELEVATOR				
Light Fixture Schedule				
Type	Description	Base Bid	Approved Alternates	Watts
A	120V, LED, 4000K, Surface wall mounted light fixture. Mount to clear elevator.	Keene RoughLite Cat # VVXL-14-NW-G1-8	Lithonia LED Vaportight cat # OLVTVWM	14
B	152mm (6") dia., 120V, LED, 1500 Lumen, 3500K, 0-10V Dimming, Gypsum board recess mounted Downlight fixture.	Lightolier ModuLite Cat # M6RDL25F935VWHZ10U c/w 8RNSR frame kit	Lithonia LBR6 Downlight Cat # LBR6 25LM 35K VR WD MVOLT UC21 c/w VWF8543	27
C	120V, LED, 3500K, Recess wall mounted direct/indirect decorative wall sconce fixture. Architect to select fixture/diffuser color finish. MH = 3400mm	OCL Cat # BA2-S15A-24-XX-XXX-LED2-935K-UNV-DM1	No Alternates	15

DRAWING LIST	
E0.01	KEY & FIRE PLAN - NOTES, LEGENDS & SCHEDULES
E1.01	EXISTING SCHOOL - NEW WORK
E1.02	GROUND & SECOND FLOOR AREA OF WORK #1 & #2
E3.01	DEMOLITION & NEW WORK - LIGHTING & LIFE SAFETY POWER & COMMUNICATIONS DETAILS
E3.02	ELECTRICAL SPECIFICATIONS - 1 OF 2
E3.03	ELECTRICAL SPECIFICATIONS - 2 OF 2

No.	YYYY/MM/DD	DESCRIPTION
3	2026/08/25	ISSUED FOR CONSTRUCTION
2	2026/07/02	ISSUED FOR TENDER
1	2026/06/30	ISSUED FOR PERMIT
0	2026/05/12	ISSUED
A	2026/04/21	ISSUED FOR COORDINATION

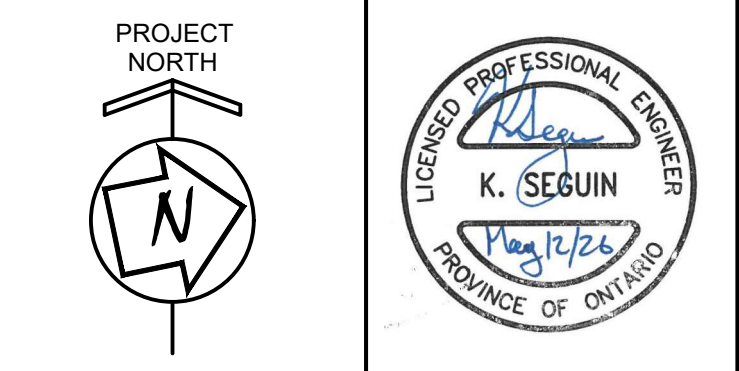

NRG DESIGN Inc.
40 Hepburn Crescent, Hamilton ON L9C 7S4
Mobile: (905) 802-7341

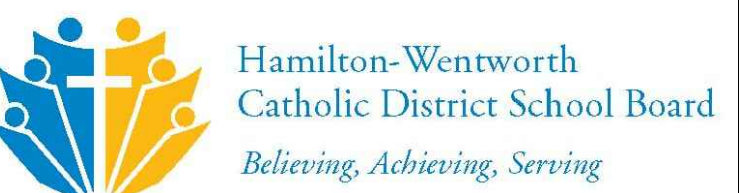

ELEVATOR FOR BISHOP TONNOS CATHOLIC SECONDARY SCHOOL

100 PANABAKER DR. ANCASTER ONTARIO

ELECTRICAL GROUND & SECOND FLOOR - AREA OF WORK #1 & #2 DEMOLITION & NEW WORK LIGHTING & LIFE SAFETY POWER & COMMUNICATIONS		
SCALE	DRAWN	PROJECT No.
AS NOTED	G.J.L.	26-006
DATE	CHECKED	DRAWING No.
2026/04/07	K.S.	E1.02